

NTS

LEGEND

Building Signs

- A** CL-VTA26 (CHANNEL LETTERS)
- B** CL-VTA35-DN (CHANNEL LETTERS)
- C** BAY DOOR LETTER SETS (N/I LETTERS)
- D** VARIOUS ENTRY DOOR/WINDOW VINYLs
- E** REPLACEMENT FACES | POLE SIGN

Interior Signs

- F** "SERVICE COUNTER" BEHIND COUNTER GRAPHICS
- G** "SERVICE COUNTER" ON COUNTER GRAPHICS
- H** "COFFEE COUNTER" GRAPHICS
- I** "TIRE WALL" GRAPHICS
- J** "WAITING ROOM" GRAPHICS
- K** "MEN/WOMEN" VINYL GRAPHICS
- L** "MEN" VINYL DOOR SYMBOL
- M** "WOMEN" VINYL DOOR SYMBOL
- N** "COFFEE BAR" VINYL WALL LEGEND
- O** "MINI GARAGE" VINYL LEGEND
- P** DIGITAL PRINT for KIDS TABLE

Property/Ground Signs

- Q** FREE-STANDING MONUMENT SIGN



VISUAL COMMUNICATIONS
www.FederalHeath.com

1128 Beville Road, Suite E Daytona Beach, FL 32114
(386) 255-1901 Fax (386) 258-0211

Manufacturing Facilities:
Oceanside, CA - Euless, TX - Jacksonville, TX
Delaware, OH - Racine, WI

Office Locations:
Oceanside, CA - Las Vegas, NV - Laughlin, AZ
Idaho Falls, ID - Euless, TX - Jacksonville, TX - San Antonio, TX
Houston, TX - Corpus Christi, TX - Indianapolis, IN
Louisville, KY - Knoxville, TN - Grafton, WI - Delaware, OH
Willowbrook, IL - Tunica, MS - Atlanta, GA
Tampa, FL - Daytona Beach, FL - Orlando, FL

Building Quality Signage Since 1901

Revisions:

R1 03-15-18 JK ADD MONUMENT SIGN (SIGN Q)

Colors Depicted In This Rendering May Not Match Actual Finished Materials. Refer To Product Samples For Exact Color Match.

Client Approval/Date: _____

Landlord Approval/Date: _____

Account Rep: **MATT SMITH**

Project Manager: **SHARNA WILSON**

Drawn By: **JKNESTRICK**

Underwriters Laboratories Inc. ELECTRICAL TO USE U.L. LISTED COMPONENTS AND SHALL MEET ALL N.E.C. STANDARDS
ALL ELECTRICAL SIGNS ARE TO COMPLY WITH U.L. 48 AND ARTICLE 600 OF THE N.E.C. STANDARDS, INCLUDING THE PROPER GROUNDING AND BONDING OF ALL SIGNS.

Project / Location:



141 MAPLE AVE.
VIENNA, VA 22180

Job Number: **23-47310-10**

Date: **03.12.18**

Sheet Number: **1** of **18**

Design Number: **23-47310-10 R1**

This original drawing is provided as part of a planned project and is not to be exhibited, copied or reproduced without the written permission of Federal Heath Sign Company, LLC or its authorized agent. ©FHSC

PROPOSED :



EXISTING :



NOTE: REMOVAL, DISPOSAL & WALL REPAIR OF EXISTING SIGNS TO BE HANDLED BY GC:



VISUAL COMMUNICATIONS
www.FederalHeath.com

1128 Beville Road, Suite E Daytona Beach, FL 32114
(386) 255-1901 Fax (386) 258-0211

Manufacturing Facilities:
Oceanside, CA - Euless, TX - Jacksonville, TX
Delaware, OH - Racine, WI

Office Locations:
Oceanside, CA - Las Vegas, NV - Laughlin, AZ
Idaho Falls, ID - Euless, TX - Jacksonville, TX - San Antonio, TX
Houston, TX - Corpus Christi, TX - Indianapolis, IN
Louisville, KY - Knoxville, TN - Grafton, WI - Delaware, OH
Willowbrook, IL - Tunica, MS - Atlanta, GA
Tampa, FL - Daytona Beach, FL - Orlando, FL

Building Quality Signage Since 1901

Revisions:

R1 03-15-18 JK ADD MONUMENT SIGN (SIGN Q)

Colors Depicted In This Rendering May Not Match Actual Finished Materials. Refer To Product Samples For Exact Color Match.

Client Approval/Date: _____

Landlord Approval/Date: _____

Account Rep: **MATT SMITH**

Project Manager: **SHARNA WILSON**

Drawn By: **JKNESTRICK**

Underwriters Laboratories Inc. **ELECTRICAL TO USE U.L. LISTED COMPONENTS AND SHALL MEET ALL N.E.C. STANDARDS**
ALL ELECTRICAL SIGNS ARE TO COMPLY WITH U.L. 48 AND ARTICLE 600 OF THE N.E.C. STANDARDS, INCLUDING THE PROPER GROUNDING AND BONDING OF ALL SIGNS.

Project / Location:



141 MAPLE AVE.
VIENNA, VA 22180

Job Number: **23-47310-10**

Date: **03.12.18**

Sheet Number: **2** of **18**


Design Number: **23-47310-10 R1**

This original drawing is provided as part of a planned project and is not to be exhibited, copied or reproduced without the written permission of Federal Heath Sign Company, LLC or its authorized agent. ©FHSC

NOTE:
 SIZES IDENTIFIED BASED ON A STANDARD 84" DOOR
 BUILDING SCALE & ARCHITECTURAL MEASUREMENTS WERE NOT PROVIDED.


FRONT ELEVATION
 51.75 L.F. (Frontage) x 2 = 103.5 SQ.FT. (ALLOWED)

SIDE ELEVATION
 109 L.F. (Frontage) x 2 = 218 SQ.FT. (ALLOWED)

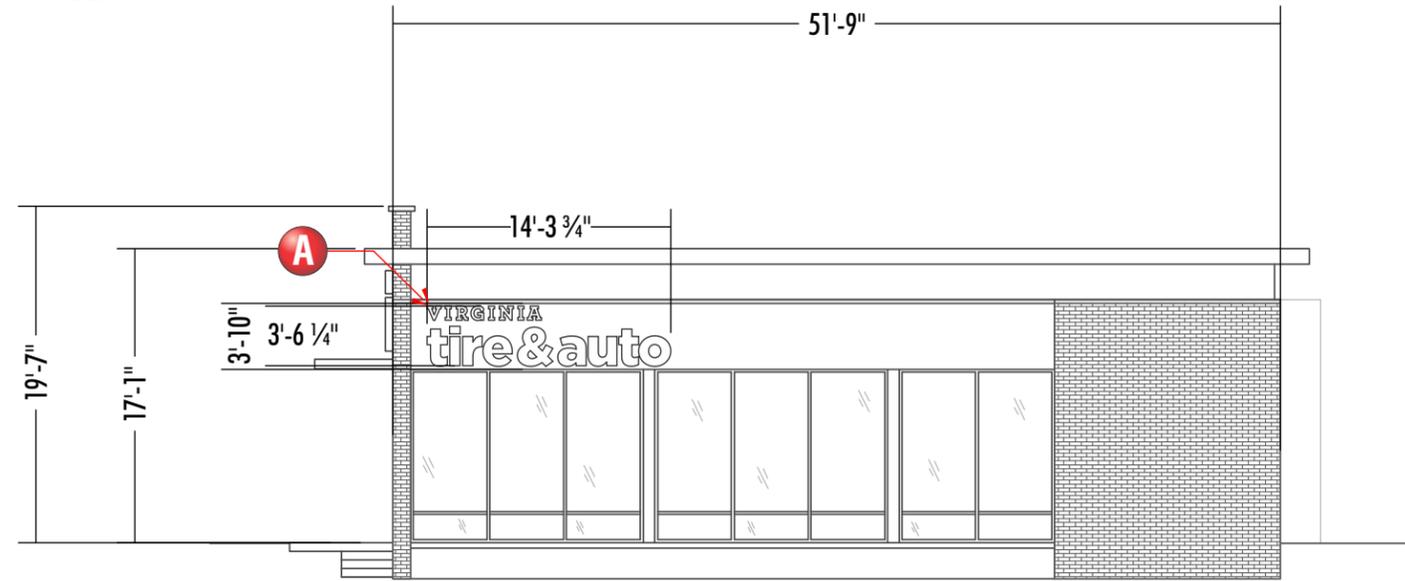

FRONT ELEVATION

scale 3/32" = 1'-0"

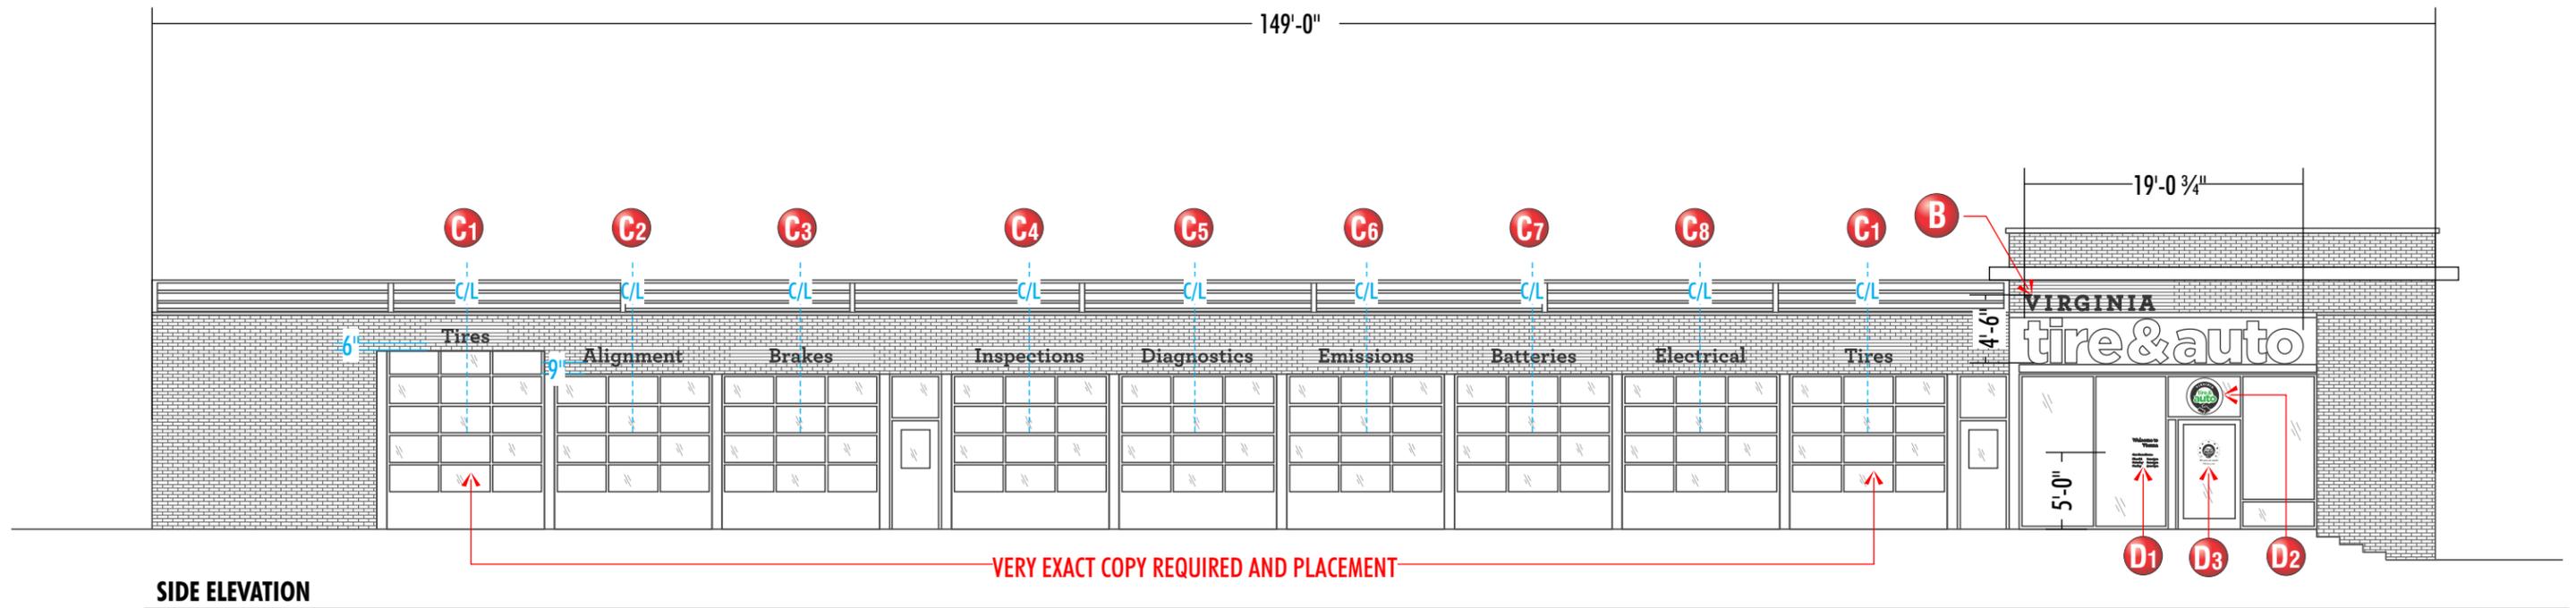

SIDE ELEVATION

scale 3/32" = 1'-0"



www.FederalHeath.com

1128 Beville Road, Suite E Daytona Beach, FL 32114
 (386) 255-1901 Fax (386) 258-0211

Manufacturing Facilities:
 Oceanside, CA - Euless, TX - Jacksonville, TX
 Delaware, OH - Racine, WI
 Office Locations:
 Oceanside, CA - Las Vegas, NV - Laughlin, AZ
 Idaho Falls, ID - Euless, TX - Jacksonville, TX - San Antonio, TX
 Houston, TX - Corpus Christi, TX - Indianapolis, IN
 Louisville, KY - Knoxville, TN - Grafton, WI - Delaware, OH
 Willowbrook, IL - Tunica, MS - Atlanta, GA
 Tampa, FL - Daytona Beach, FL - Orlando, FL

Building Quality Signage Since 1901

Revisions:

R1 03-15-18 JK ADD MONUMENT SIGN (SIGN Q)

Colors Depicted In This Rendering May Not Match Actual Finished Materials. Refer To Product Samples For Exact Color Match.

Client Approval/Date: _____

Landlord Approval/Date: _____

Account Rep: **MATT SMITH**

Project Manager: **SHARNA WILSON**

Drawn By: **JKNESTRICK**

Underwriters Laboratories Inc. **nec** ELECTRICAL TO USE U.L. LISTED COMPONENTS AND SHALL MEET ALL N.E.C. STANDARDS
 ALL ELECTRICAL SIGNS ARE TO COMPLY WITH U.L. 48 AND ARTICLE 600 OF THE N.E.C. STANDARDS, INCLUDING THE PROPER GROUNDING AND BONDING OF ALL SIGNS.

Project / Location:



141 MAPLE AVE.
 VIENNA, VA 22180


Job Number: 23-47310-10

Date: 03.12.18

Sheet Number: 3 of 18

Design Number: 23-47310-10 R1

This original drawing is provided as part of a planned project and is not to be exhibited, copied or reproduced without the written permission of Federal Heath Sign Company, LLC or its authorized agent. ©FHSC


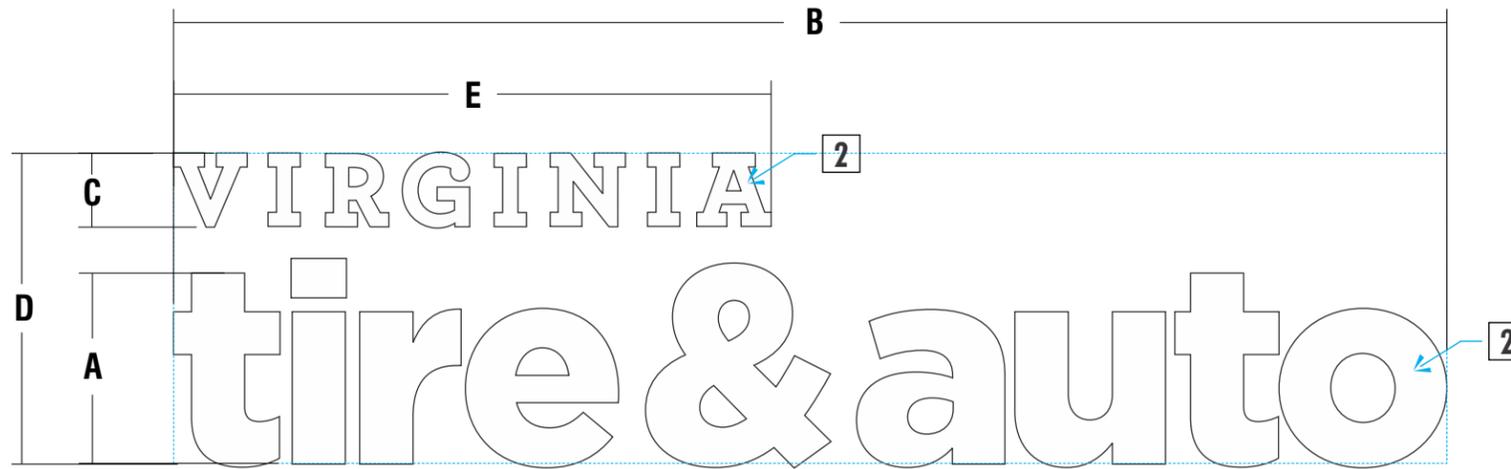


A INTERNALLY ILLUMINATED CHANNEL LETTERS (REMOTE) | ALL WHITE OPTION

LETTER SET MATRIX - Remote - (All-White)

SIGN TYPE	A	B	C	D	E	SQ.FT. (1 BOX)	SQ.FT. (2 BOXES)	QTY
CL-VTA26	2'-2"	14'-3 3/4"	10"	3'-6 1/4"	6'-8 1/2"	50.3	38.0	1

<p>GLOSS WHITE</p> <p>1</p> <p>RETURNS / TRIM CAP</p>	<p>#2447 WHITE</p> <p>2</p> <p>FACES</p>	<p>WHITE LED</p> <p>ILLUMINATION</p>
--	---	--------------------------------------

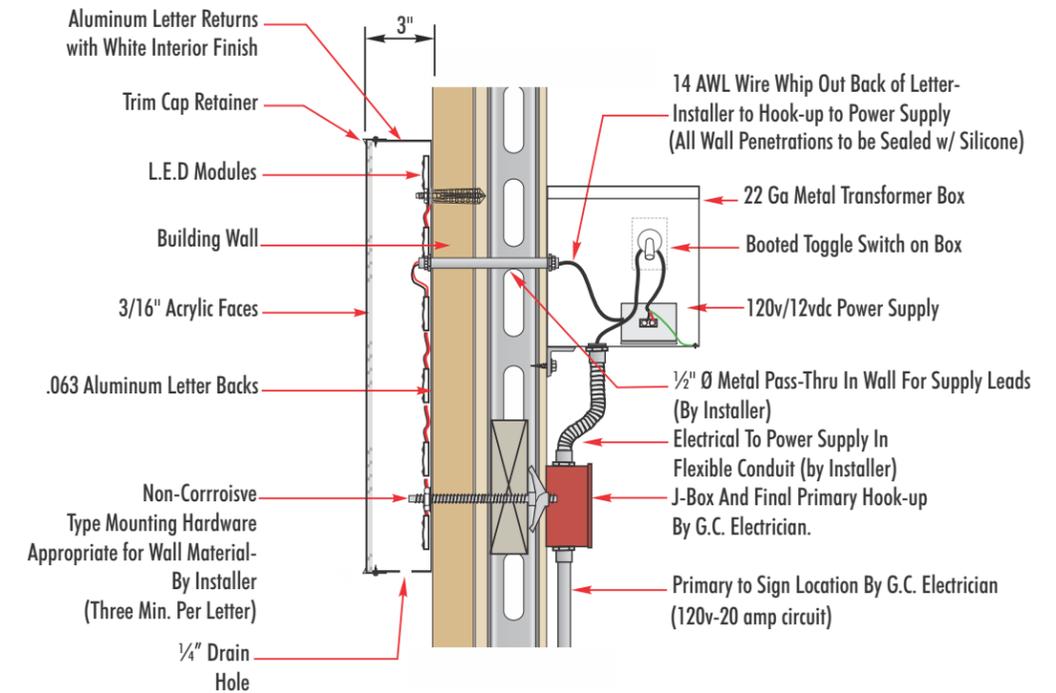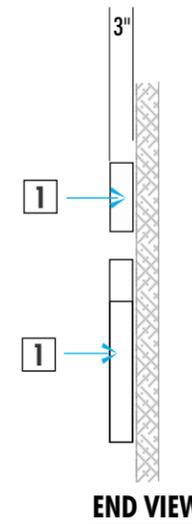

SECTION DETAIL - LED ILLUMINATED WALL LETTERS

GENERAL NOTE

• INSTALLER SHALL VERIFY WALL CONDITIONS IN THE FIELD • TYPE, SIZE & QUANTITY OF FASTENERS TO BE DETERMINED • ALL BOLT HOLES TO BE DRILLED OR PUNCHED • ISOLATE ALL ALUMINUM FROM STEEL.

NEW & REMODEL CONSTRUCTION
ADEQUATE BEHIND THE WALL BACKING AND ACCESS IS REQUIRED FOR THE INSTALLATION OF NEW SIGNAGE. CUSTOMER TO FORWARD APPROVED SIGNAGE DRAWINGS TO THE ON SITE CONTACT TO INSURE THAT THE REQUIRED PROVISIONS ARE MADE DURING CONSTRUCTION, PRIOR TO THE SIGN INSTALLATION.

INSTALLER REQUIREMENTS
ALL INSTALLATION (MOUNTING) HARDWARE AND SECONDARY WIRING COMPONENTS, CONDUIT & CONNECTORS, ETC. ARE TO BE PROVIDED BY THE INSTALLATION CONTRACTOR.

ALL ELECTRICAL SIGNS SHALL CONFORM TO THE REQUIREMENTS OF ARTICLE 600 OF THE N.E.C. AND U.L. 48 ALONG WITH OTHER APPLICABLE STATE & LOCAL CODE REQUIREMENTS. THIS INCLUDES PROPER GROUNDING AND BONDING OF THE SIGN

120V - 20 AMP (PRIMARY ELECTRICAL SERVICE) CIRCUITS AND FINAL CONNECTION TO EACH SIGN, TO WITHIN 6 FT TO BE BY THE CUSTOMER'S CERTIFIED ELECTRICIAN. NUMBER AND SIZE OF CIRCUITS FOR EACH SIGN TO MEET FEDERAL HEALTH SIGN COMPANY REQUIREMENTS

CUSTOMER TO PROVIDE DEDICATED BRANCH CIRCUITS FOR SIGNS ONLY PER NEC CODE 600.5

ALL BRANCH CIRCUITS FOR SIGNS MUST BE TOTALLY DEDICATED TO SIGNS (INCLUDING DEDICATED GROUND & NEUTRAL PER CIRCUIT) AND SHALL NOT BE SHARED WITH OTHER LOADS (SUCH AS LIGHTING, A/C and OTHER EQUIPMENT). PROPERLY SIZED GROUND WIRE THAT CAN BE TRACED BACK TO THE BREAKER PANEL IS REQUIRED.

NUMBER AND SIZE OF CIRCUITS FOR EACH SIGN MUST MEET FEDERAL HEALTH SIGN REQUIREMENTS.

WARRANTY NOTICE

CERTAIN ELECTRICAL COMPONENTS OF SIGNS WILL FAIL PREMATURELY IF NOT SHUT OFF FOR A PERIOD OF TIME, ONCE EACH DAY. FOR BEST PERFORMANCE WE RECOMMEND THAT SIGNS BE CONNECTED TO AN AUTOMATIC CONTROLLING DEVICE SUCH AS AN EMERGENCY MANAGEMENT SYSTEM, TIME CLOCK OR PHOTO CELL TO CONTROL THE DAILY SHUT-OFF PERIOD. FAILURE TO FOLLOW THESE RECOMMENDATIONS CAN CAUSE DAMAGE TO ELECTRICAL COMPONENTS OF THE SIGN AND VOID THE WARRANTY. SOME DIMMING DEVICES WILL ADVERSELY AFFECT THE ELECTRICAL COMPONENTS OF THE SIGN IT IS ATTACHED TO, CAUSING FAILURE. ANY DIMMING OF THE SIGN WITHOUT CONSULTATION WITH FEDERAL HEALTH SIGN CO. WILL VOID THE WARRANTY.

FEDERAL HEATH
VISUAL COMMUNICATIONS
www.FederalHeath.com
1128 Beville Road, Suite E Daytona Beach, FL 32114
(386) 255-1901 Fax (386) 258-0211

Manufacturing Facilities:
Oceanside, CA - Eules, TX - Jacksonville, TX
Delaware, OH - Racine, WI
Office Locations:
Oceanside, CA - Las Vegas, NV - Laughlin, AZ
Idaho Falls, ID - Eules, TX - Jacksonville, TX - San Antonio, TX
Houston, TX - Corpus Christi, TX - Indianapolis, IN
Louisville, KY - Knoxville, TN - Grafton, WI - Delaware, OH
Wilmington, IL - Tunica, MS - Atlanta, GA
Tampa, FL - Daytona Beach, FL - Orlando, FL

Revisions: _____
R1 03-15-18 JK ADD MONUMENT SIGN (SIGN Q) _____

Colors Depicted In This Rendering May Not Match Actual Finished Materials. Refer To Product Samples For Exact Color Match.
Client Approval/Date: _____
Landlord Approval/Date: _____

Account Rep: **MATT SMITH**
Project Manager: **SHARNA WILSON**
Drawn By: **JKNESTRICK**
Underwriters Laboratories Inc. nfc
ELECTRICAL TO USE U.L. LISTED COMPONENTS AND SHALL MEET ALL N.E.C. STANDARDS
ALL ELECTRICAL SIGNS ARE TO COMPLY WITH U.L. 48 AND ARTICLE 600 OF THE N.E.C. STANDARDS, INCLUDING THE PROPER GROUNDING AND BONDING OF ALL SIGNS.

Project / Location:
141 MAPLE AVE.
VIENNA, VA 22180

Job Number: 23-47310-10
Date: 03.12.18
Sheet Number: 4 of 18
Design Number: 23-47310-10 R1

This original drawing is provided as part of a planned project and is not to be exhibited, copied or reproduced without the written permission of Federal Heath Sign Company, LLC or its authorized agent. ©FHSC



B INTERNALLY ILLUMINATED CHANNEL LETTERS (REMOTE) | BLACK & WHITE OPTION

LETTER SET MATRIX - Remote - Virginia (Day-Night)

SIGN TYPE	A	B	C	D	E	SQ.FT. <small>(1 BOX)</small>	SQ.FT. <small>(2 BOXES)</small>	QTY
CL-VTA35-DN	2'-10 3/4"	19'-0 3/4"	12 1/4"	4'-6"	8'-2 1/2"	85.8	63.6	1

<p>GLOSS BLACK</p> <p>1</p> <p>RETURNS / TRIM CAP</p>	<p>GLOSS WHITE</p> <p>2</p> <p>RETURNS / TRIM CAP</p>	<p>#3635-222 3M DUAL-COLOR FILM</p> <p>3</p> <p>FACES (DAY/NIGHT)</p>	<p>#2447 WHITE</p> <p>4</p> <p>FACES</p>	<p>WHITE LED</p> <p>ILLUMINATION</p>
---	---	---	--	--------------------------------------

GENERAL NOTE

• INSTALLER SHALL VERIFY WALL CONDITIONS IN THE FIELD • TYPE, SIZE & QUANTITY OF FASTENERS TO BE DETERMINED • ALL BOLT HOLES TO BE DRILLED OR PUNCHED • ISOLATE ALL ALUMINUM FROM STEEL.

NEW & REMODEL CONSTRUCTION
ADEQUATE BEHIND THE WALL BACKING AND ACCESS IS REQUIRED FOR THE INSTALLATION OF NEW SIGNAGE. CUSTOMER TO FORWARD APPROVED SIGNAGE DRAWINGS TO THE ON SITE CONTACT TO INSURE THAT THE REQUIRED PROVISIONS ARE MADE DURING CONSTRUCTION, PRIOR TO THE SIGN INSTALLATION.

INSTALLER REQUIREMENTS
ALL INSTALLATION (MOUNTING) HARDWARE AND SECONDARY WIRING COMPONENTS, CONDUIT & CONNECTORS, ETC. ARE TO BE PROVIDED BY THE INSTALLATION CONTRACTOR.
ALL WALL PENETRATIONS TO BE SEALED WITH SILICONE TO HELP PREVENT MOISTURE PENETRATION @ EXTERIOR LOCATIONS.

ALL ELECTRICAL SIGNS SHALL CONFORM TO THE REQUIREMENTS OF ARTICLE 600 OF THE N.E.C. AND U.L. 48 ALONG WITH OTHER APPLICABLE STATE & LOCAL CODE REQUIREMENTS. THIS INCLUDES PROPER GROUNDING AND BONDING OF THE SIGN

120V - 20 AMP (PRIMARY ELECTRICAL SERVICE) CIRCUITS AND FINAL CONNECTION TO EACH SIGN, TO WITHIN 6 FT TO BE BY THE CUSTOMER'S CERTIFIED ELECTRICIAN. NUMBER AND SIZE OF CIRCUITS FOR EACH SIGN TO MEET FEDERAL HEATH SIGN COMPANY REQUIREMENTS

CUSTOMER TO PROVIDE DEDICATED BRANCH CIRCUITS FOR SIGNS ONLY PER NEC CODE 600.5


ALL BRANCH CIRCUITS FOR SIGNS MUST BE TOTALLY DEDICATED TO SIGNS (INCLUDING DEDICATED GROUND & NEUTRAL PER CIRCUIT) AND SHALL NOT BE SHARED WITH OTHER LOADS (SUCH AS LIGHTING, A/C and OTHER EQUIPMENT). PROPERLY SIZED GROUND WIRE THAT CAN BE TRACED BACK TO THE BREAKER PANEL IS REQUIRED.

WARRANTY NOTICE

CERTAIN ELECTRICAL COMPONENTS OF SIGNS WILL FAIL PREMATURELY IF NOT SHUT OFF FOR A PERIOD OF TIME, ONCE EACH DAY. FOR BEST PERFORMANCE WE RECOMMEND THAT SIGNS BE CONNECTED TO AN AUTOMATIC CONTROLLING DEVICE SUCH AS AN EMERGENCY MANAGEMENT SYSTEM, TIME CLOCK OR PHOTO CELL TO CONTROL THE DAILY SHUT-OFF PERIOD. FAILURE TO FOLLOW THESE RECOMMENDATIONS CAN CAUSE DAMAGE TO ELECTRICAL COMPONENTS OF THE SIGN AND VOID THE WARRANTY. SOME DIMMING DEVICES WILL ADVERSELY AFFECT THE ELECTRICAL COMPONENTS OF THE SIGN IT IS ATTACHED TO, CAUSING FAILURE. ANY DIMMING OF THE SIGN WITHOUT CONSULTATION WITH FEDERAL HEATH SIGN CO. WILL VOID THE WARRANTY.

NUMBER AND SIZE OF CIRCUITS FOR EACH SIGN MUST MEET FEDERAL HEATH SIGN REQUIREMENTS.

LOW VOLTAGE L.E.D. LIGHTING SYSTEM
U.L. LISTED CLASS 2 - CONFORMS TO U.L. 48 & NEC 600 CODE

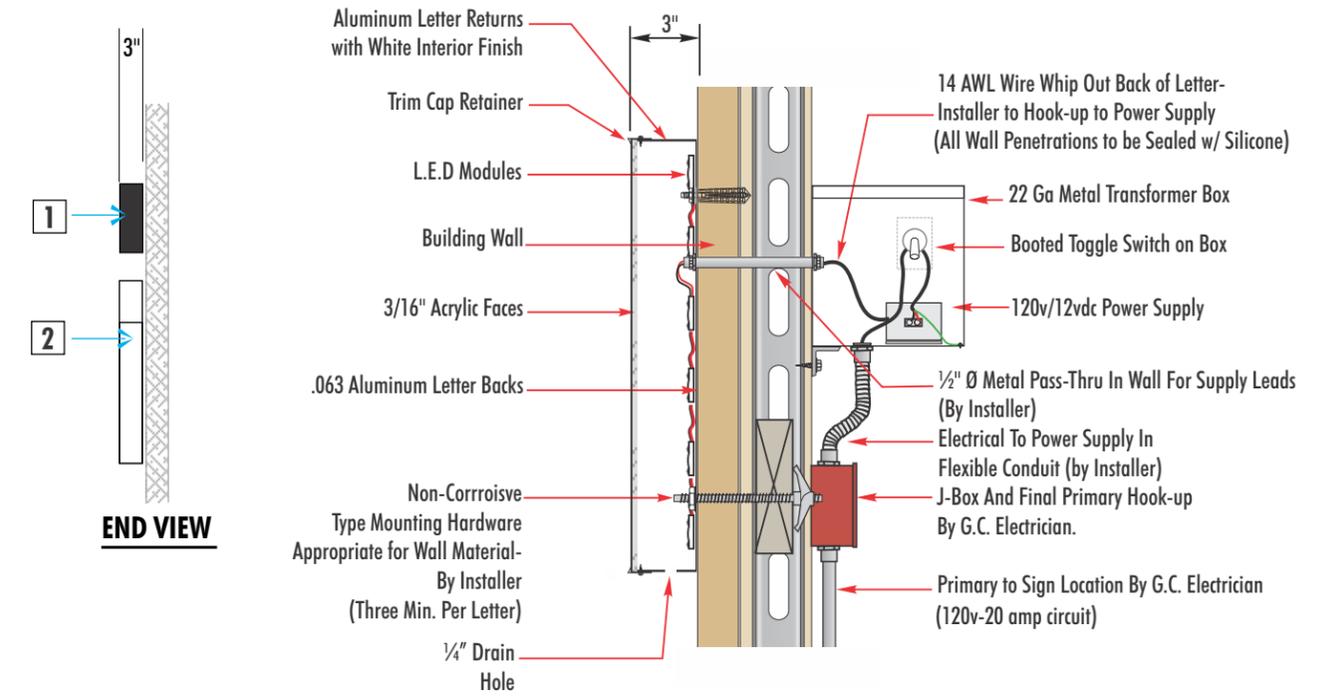

SECTION DETAIL - LED ILLUMINATED WALL LETTERS

FEDERAL HEATH
VISUAL COMMUNICATIONS
www.FederalHeath.com
1128 Beville Road, Suite E Daytona Beach, FL 32114
(386) 255-1901 Fax (386) 258-0211

Manufacturing Facilities:
Oceanside, CA - Euless, TX - Jacksonville, TX
Delaware, OH - Racine, WI
Office Locations:
Oceanside, CA - Las Vegas, NV - Laughlin, AZ
Idaho Falls, ID - Euless, TX - Jacksonville, TX - San Antonio, TX
Houston, TX - Corpus Christi, TX - Indianapolis, IN
Louisville, KY - Knoxville, TN - Grafton, WI - Delaware, OH
Willowbrook, IL - Tunica, MS - Atlanta, GA
Tampa, FL - Daytona Beach, FL - Orlando, FL

Revisions:
R1 03-15-18 JK ADD MONUMENT SIGN (SIGN Q)
Colors Depicted In This Rendering May Not Match Actual Finished Materials. Refer To Product Samples For Exact Color Match.
Client Approval/Date: _____
Landlord Approval/Date: _____

Account Rep: **MATT SMITH**
Project Manager: **SHARNA WILSON**
Drawn By: **JKNESTRICK**
Underwriters Laboratories Inc. nēc
ELECTRICAL TO USE U.L. LISTED COMPONENTS AND SHALL MEET ALL N.E.C. STANDARDS
ALL ELECTRICAL SIGNS ARE TO COMPLY WITH U.L. 48 AND ARTICLE 600 OF THE N.E.C. STANDARDS, INCLUDING THE PROPER GROUNDING AND BONDING OF ALL SIGNS.

Project / Location:

141 MAPLE AVE.
VIENNA, VA 22180

Job Number: 23-47310-10
Date: 03.12.18
Sheet Number: 5 of 18
Design Number: 23-47310-10 R1

This original drawing is provided as part of a planned project and is not to be exhibited, copied or reproduced without the written permission of Federal Heath Sign Company, LLC or its authorized agent. ©FHSC



C1 INDIVIDUAL NON-ILLUMINATED LETTER LAYOUT | TWO (2) SET REQ



C2 INDIVIDUAL NON-ILLUMINATED LETTER LAYOUT | ONE (1) SET REQ



C3 INDIVIDUAL NON-ILLUMINATED LETTER LAYOUT | ONE (1) SETS REQ



C4 INDIVIDUAL NON-ILLUMINATED LETTER LAYOUT | ONE (1) SETS REQ



C5 INDIVIDUAL NON-ILLUMINATED LETTER LAYOUT | ONE (1) SETS REQ



C6 INDIVIDUAL NON-ILLUMINATED LETTER LAYOUT | ONE (1) SETS REQ




C7 INDIVIDUAL NON-ILLUMINATED LETTER LAYOUT | ONE (1) SET REQ




C8 INDIVIDUAL NON-ILLUMINATED LETTER LAYOUT | ONE (1) SET REQ


C EXTERIOR INDIVIDUAL NON-ILLUMINATED LETTER SETS
scale 3/8" = 1'-0" 44.1 S.F. (TOTAL)

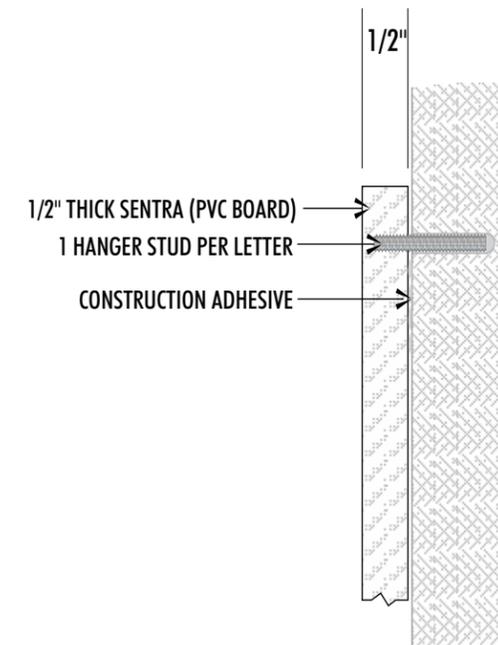

CROSS-SECTION
scale 6" = 1'-0"

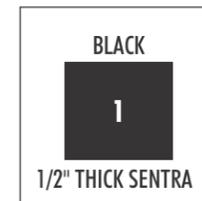

FONT: Archer Bold

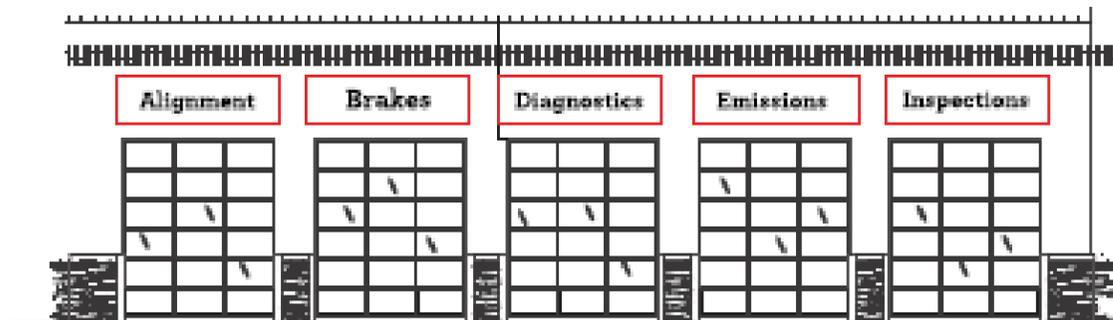

TYPICAL BAY DOOR ELEVATION (GENERIC)

not to scale




1 STORE HOURS (VERIFY EXACT HOURS)
3.1 S.F.

D VARIOUS GLASS WINDOW & DOOR VINYL LAYOUTS
scale 1 1/2" = 1'-0" APPLICATION: FIRST SURFACE
FONT: Archer Semi-Bold


GREEN PMS 361	100 % WHITE	100% BLACK
FINISH: MATTE		




2 TRANSOM LOGO
6.2 S.F. DIGITAL PRINT ON WHITE VINYL (FIRST SURFACE)

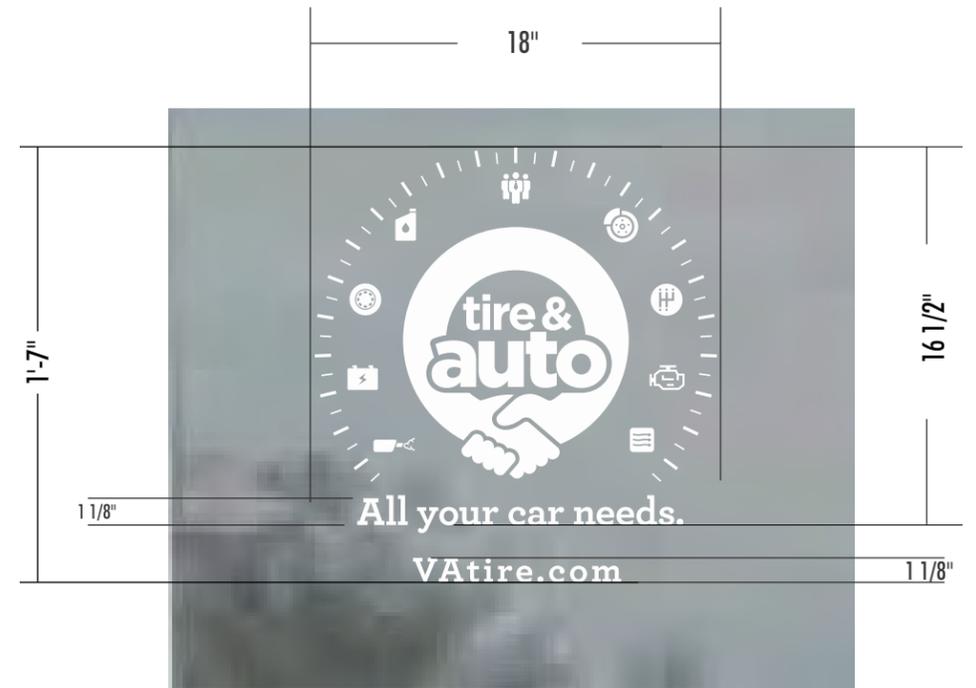

3 ENTRY LOGO & GRAPHICS
2.3 S.F.

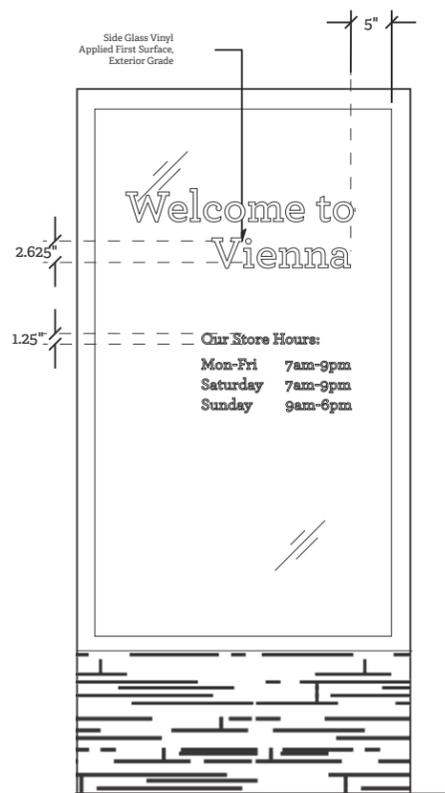

1 Front Door Vinyl Elevation View
scale 1/2" = 1'-0"

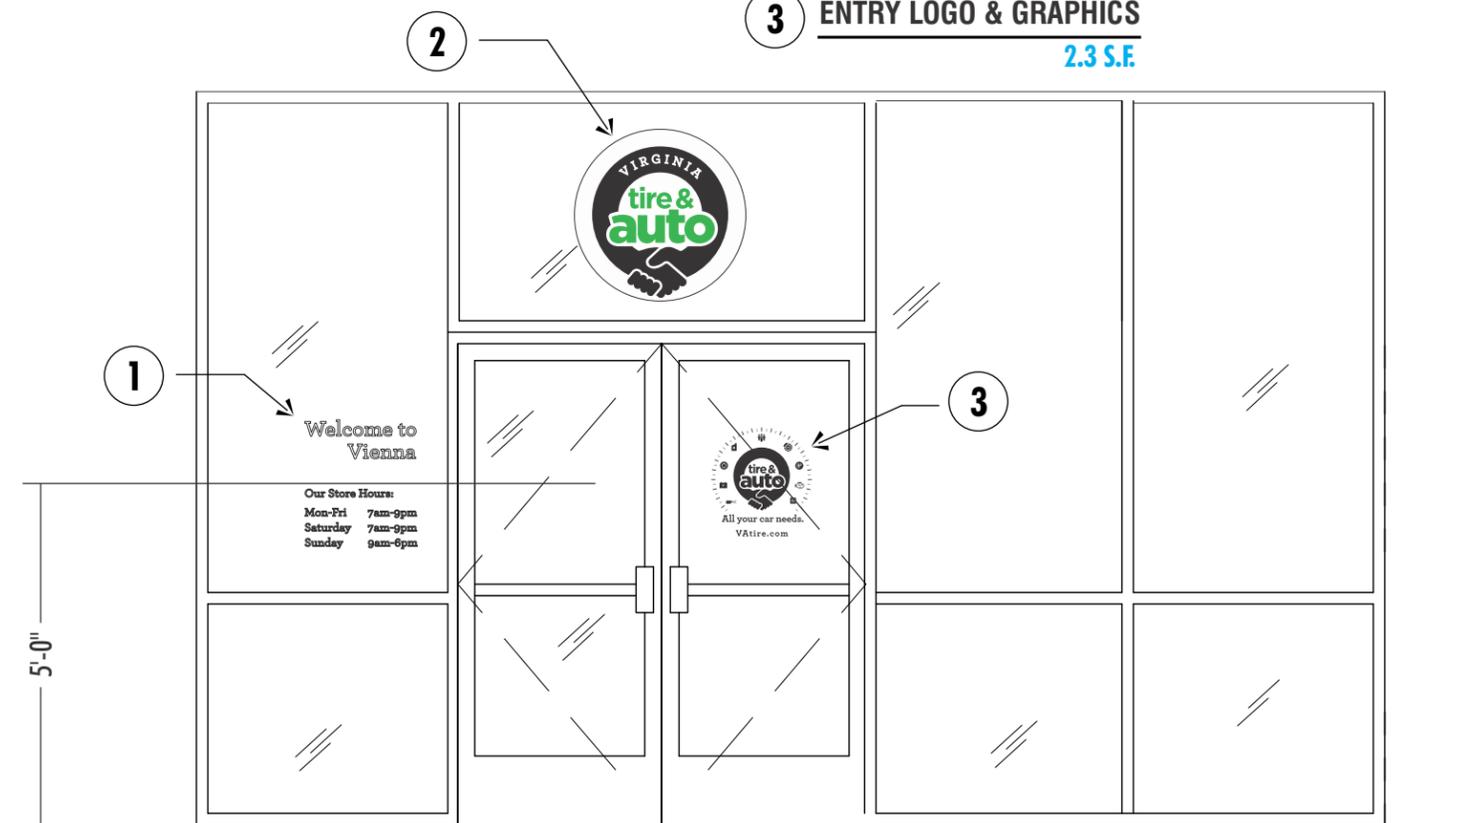

TYPICAL FRONT ENTRY ELEVATION scale 3/8" = 1'-0"

FIELD SURVEY REQUIRED



EXISTING LOOK

E

REPLACEMENT FACE LAYOUT | TWO(2) REQ

scale 3/8" = 1'-0"

DESCRIPTION OF WORK

MANUFACTURE AND INSTALL TWO(2) PAN-FORMED, NON-EMBOSSD REPLACEMENT FACES AS SHOWN AND NOTED. FACES OF WHITE ACRYLSTEEL (OR EQUIVALENT) with FIRST SURFACE TRANSLUCENT VINYL DECORATION.

<p>BLACK VINYL</p> <div style="background-color: black; width: 30px; height: 30px; margin: 0 auto; display: flex; align-items: center; justify-content: center;">1</div> <p>3630-22</p>	<p>LIME GREEN</p> <div style="background-color: limegreen; width: 30px; height: 30px; margin: 0 auto; display: flex; align-items: center; justify-content: center;">2</div> <p>3630-136</p>	<p>ACRYLIC/POLYCARB</p> <div style="border: 1px solid black; width: 30px; height: 30px; margin: 0 auto; display: flex; align-items: center; justify-content: center;">3</div> <p>WHITE FACES</p>
---	---	--



PROPOSED NEW LOOK



VISUAL COMMUNICATIONS
www.FederalHeath.com

1128 Beville Road, Suite E Daytona Beach, FL 32114
(386) 255-1901 Fax (386) 258-0211

Manufacturing Facilities:
Oceanside, CA - Euless, TX - Jacksonville, TX
Delaware, OH - Racine, WI

Office Locations:
Oceanside, CA - Las Vegas, NV - Laughlin, AZ
Idaho Falls, ID - Euless, TX - Jacksonville, TX - San Antonio, TX
Houston, TX - Corpus Christi, TX - Indianapolis, IN
Louisville, KY - Knoxville, TN - Grafton, WI - Delaware, OH
Willowbrook, IL - Tunica, MS - Atlanta, GA
Tampa, FL - Daytona Beach, FL - Orlando, FL

Building Quality Signage Since 1901

Revisions:

R1 03-15-18 JK ADD MONUMENT SIGN (SIGN Q)

Colors Depicted In This Rendering May Not Match Actual Finished Materials. Refer To Product Samples For Exact Color Match.

Client Approval/Date: _____

Landlord Approval/Date: _____

Account Rep: **MATT SMITH**

Project Manager: **SHARNA WILSON**

Drawn By: **JKNESTRICK**

Underwriters Laboratories Inc. ELECTRICAL TO USE U.L. LISTED COMPONENTS AND SHALL MEET ALL N.E.C. STANDARDS. ALL ELECTRICAL SIGNS ARE TO COMPLY WITH U.L. 48 AND ARTICLE 600 OF THE N.E.C. STANDARDS, INCLUDING THE PROPER GROUNDING AND BONDING OF ALL SIGNS.

Project / Location:



141 MAPLE AVE.
VIENNA, VA 22180


Job Number: **23-47310-10**

Date: **03.12.18**

Sheet Number: **8** of **18**

Design Number: **23-47310-10 R1**

This original drawing is provided as part of a planned project and is not to be exhibited, copied or reproduced without the written permission of Federal Heath Sign Company, LLC or its authorized agent. ©FHSC

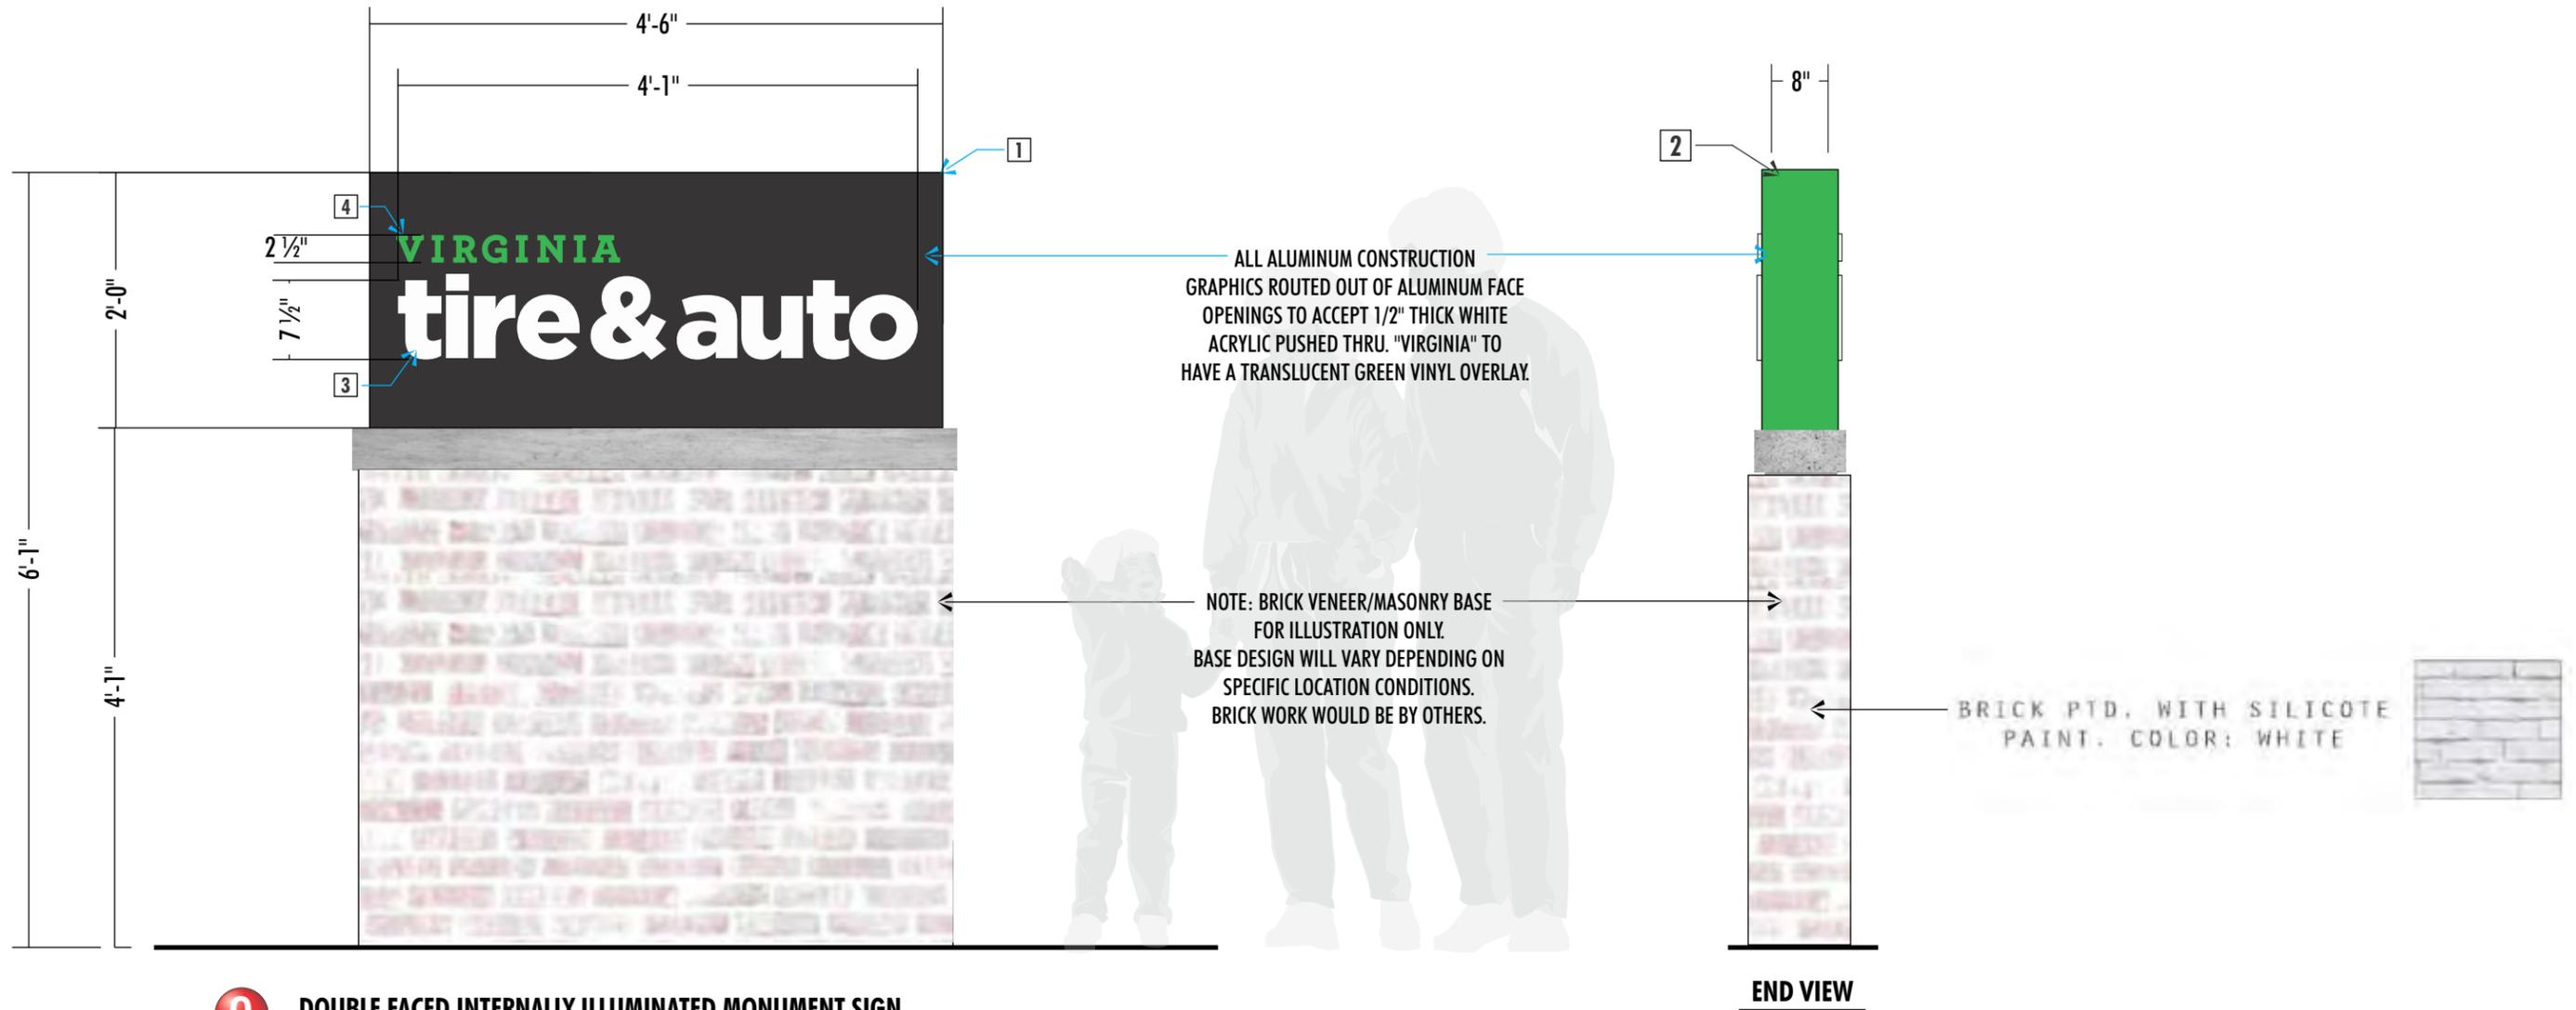

Q **DOUBLE FACED INTERNALLY ILLUMINATED MONUMENT SIGN**
 scale 3/4" = 1'-0" 9 S.F.

BLACK 1 100%	GREEN 2 PMS 361C	ACRYLIC 3 1/2" THICK WHITE	LIME GREEN 4 3630-136	WHITE LED ILLUMINATION
---------------------------	-------------------------------	---	------------------------------------	----------------------------------